


DESCRIPTION :

**ONE COMMUNITY
 DUPLICABLE CITY**

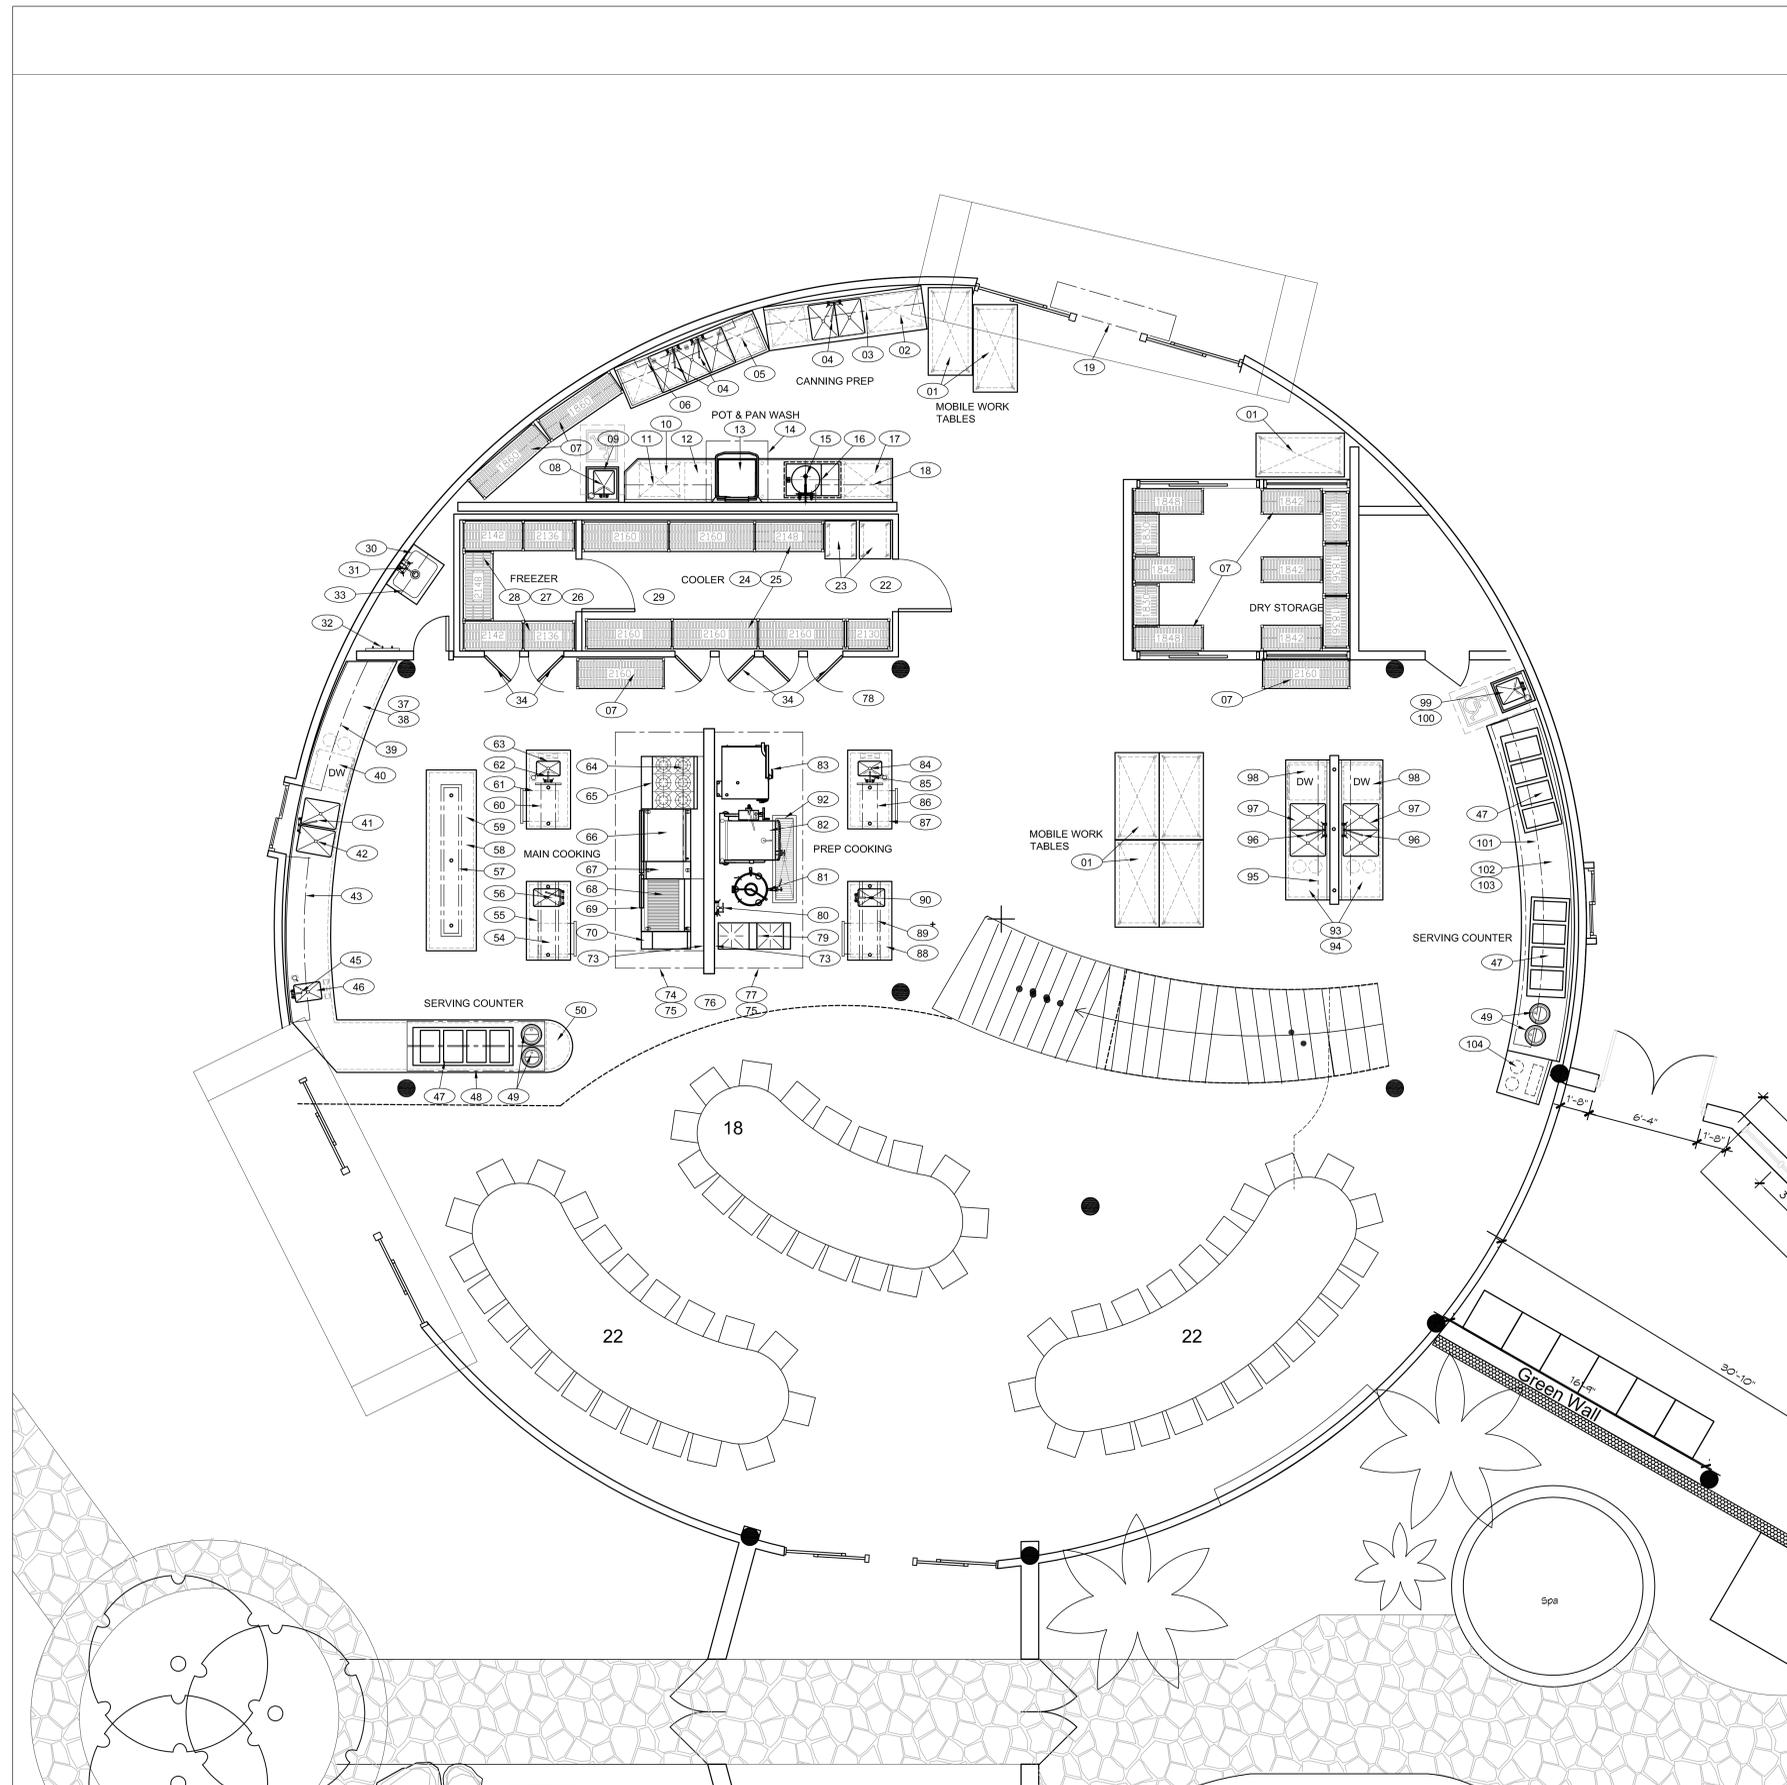

EQUIPMENT FLOOR PLAN

THIS PLAN IS A GENERAL ARRANGEMENT OF EQUIPMENT FOR THE CONVENIENCE OF CONTRACTORS AND IS MADE FROM AVAILABLE INFORMATION. WEBB DESIGN ASSUMES NO RESPONSIBILITY FOR THE ACCURACY OF SUCH MEASUREMENTS. FABRICATORS, CONTRACTORS AND OTHERS UTILIZING THESE PLANS IN CONNECTION WITH THIS JOB ARE RESPONSIBLE FOR SECURING THEIR OWN MEASUREMENTS. PLUMBING AND ELECTRICAL INFORMATION INDICATED ON THESE PLANS ARE GENERALLY FOR FOOD SERVICE EQUIPMENT AND ARE INTENDED AS REFERENCE ONLY. WEBB DESIGN IS NOT RESPONSIBLE FOR THE ENGINEERING THERE OF OR FOR ANY PLUMBING OR ELECTRICAL FITTINGS, WORK, AND OR CONNECTIONS UNLESS SPECIFICALLY PROVIDED FOR IN THE SPECIFICATIONS. WEBB DESIGN ASSUMES NO RESPONSIBILITY FOR THE WORK DONE BY THE CONTRACTORS NOR FOR ANY CHANGES MADE NECESSARY BY THE LOCAL BUILDING CODES, ORDINANCES, STRUCTURAL CONDITIONS, OR BY THE SUBSTITUTION OR CHANGES MADE NECESSARY IN EQUIPMENT SHOWN ON THIS PLAN. CONTRACTORS ARE TO MAKE ALLOWANCES FOR ELBOWS, TRAPS, ETC. AND ARE TO MAKE FINAL CONNECTIONS ON THE JOB. SUPPLYING ALL NECESSARY VALVES, TRAPS, STEAM TRAPS, FAUCETS, STARTING SWITCHES FOR MOTORS, ETC. EXCEPT WHERE SPECIFICALLY NOTED OTHERWISE IN THE WRITTEN SPECIFICATIONS. THESE PLANS AND DESIGNS CONTAINED HEREIN ARE THE PROPERTY OF WEBB DESIGN AND MAY NOT BE REPRODUCED OR USED BY ANYONE, EITHER ALL OR IN PART, WITHOUT FIRST SECURING THE WRITTEN PERMISSION OF WEBB DESIGN.

REVISION	DESCRIPTION	DATE
△		
△		
△		
△		

SHEET DESCRIPTION :

EQUIPMENT FLOOR PLAN

DATE :

SCALE :
 1/4" = 1'-0"

PROJECT NUMBER :

CADD FILE :
 FS-101.dwg

SHEET NUMBER :

FS-101

DO NOT SCALE PRINTS

